



P:\2014\14-190-000 Henrietta EMS and Library\CD's\X-plan 09.23.2014.dwg, Plotted By: sponder, Plotted: Oct 07, 2014 - 11:02am

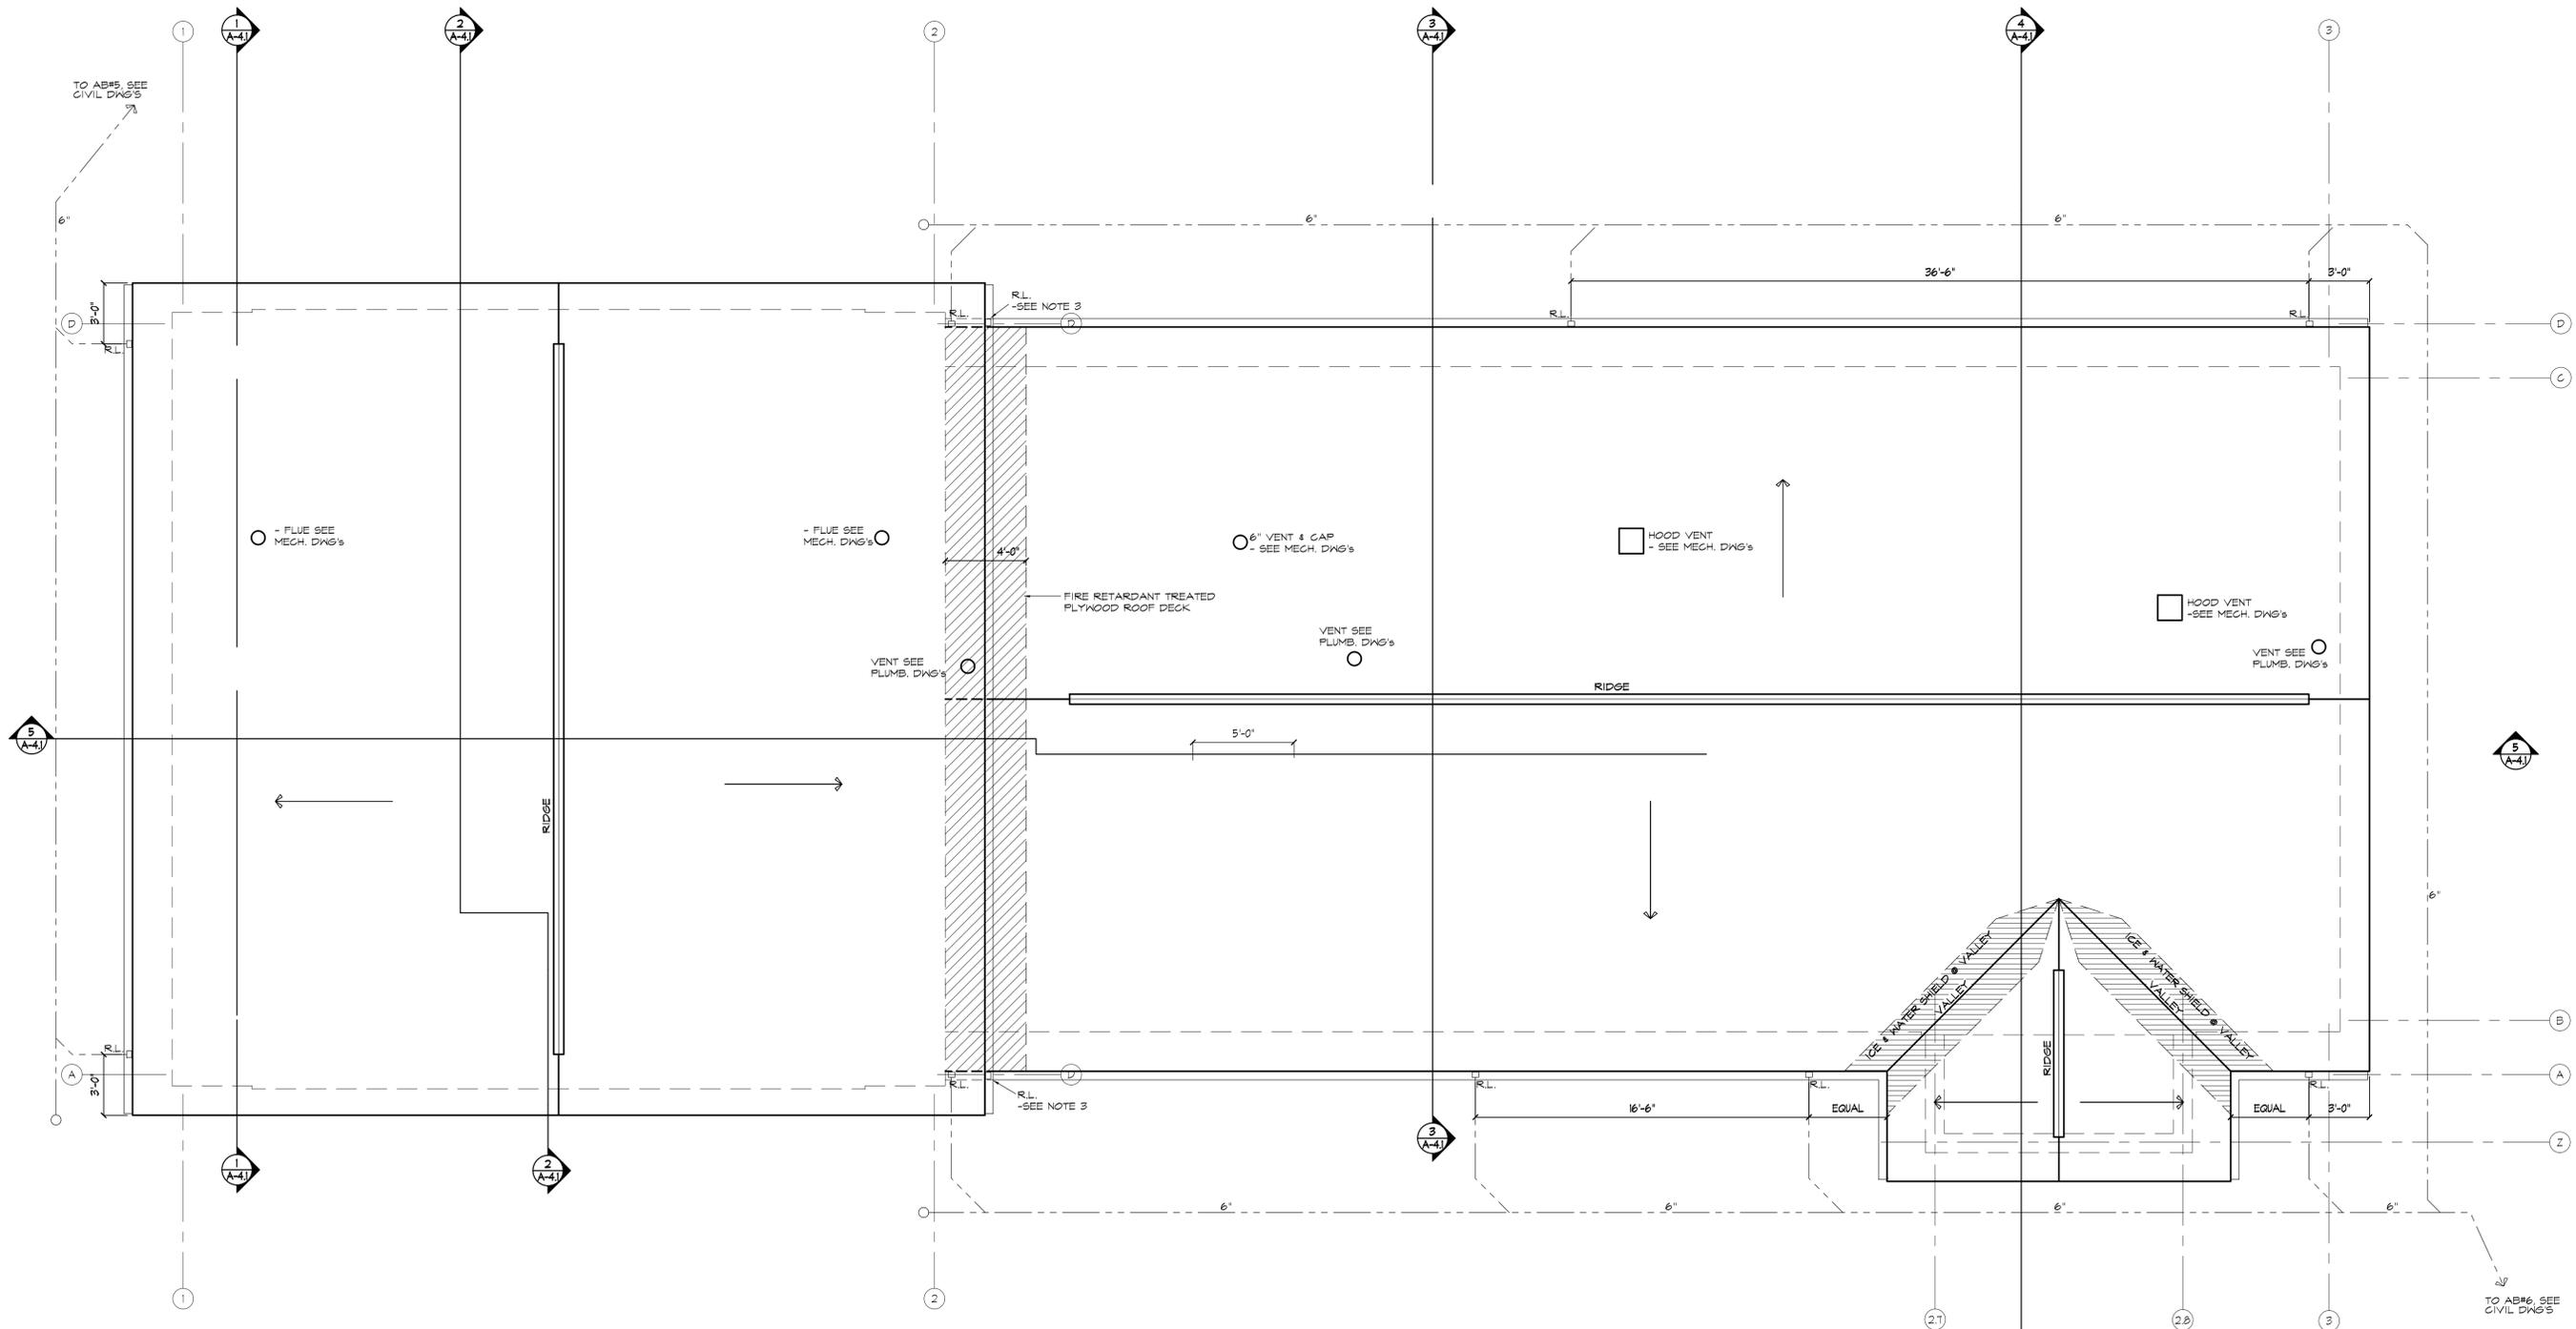

1 ROOF PLAN  
SCALE: 1/4"=1'-0"

ROOF LEGEND

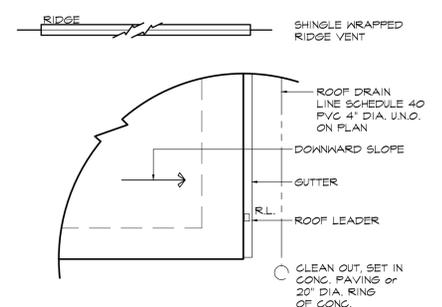

ROOF PLAN NOTES

1. ROOF PITCH 4:12 SLOPE, UNLESS NOTED OTHERWISE.
2. REFER TO MECHANICAL, PLUMBING AND ELECTRICAL DRAWINGS FOR LOCATIONS OF ADDITIONAL PIPING, CURBS, VENTS, DUCTS, FANS AND OTHER ITEMS ON THE ROOF SURFACE NOT SHOWN ON THE ROOF PLAN OR ELEVATIONS.
3. DOWNSPOUT FROM HIGH ROOF TO EMPTY INTO GUTTER BELOW

ESD  
architecture + interior design

1300 South Mint Street, Suite 300, Charlotte, NC 28203  
 Email: esd@esdarch.com • Fax: 704-373-0902 • Phone: 704-373-1900

SOUTHEASTERN EMS  
 NEW SOUTHEASTERN EMS  
 FOR  
 RUTHERFORD COUNTY

ISSUE DATE: 10-7-14

REVISION 1: --  
 REVISION 2: --  
 REVISION 3: --  
 REVISION 4: --

PROJECT #: 14-190-00  
 CONTENT: ROOF PLAN  
 ARCHITECT: --  
 DRAWN BY: SJP  
 CADD FILE NAME: --

THIS DRAWING AND THE DESIGN SHOWN ARE THE PROPERTY OF ESD. THE REPRODUCTION, OR USE OF THIS DRAWING, WITHOUT THEIR WRITTEN CONSENT IS PROHIBITED. ANY INFRINGEMENT IS SUBJECT TO LEGAL ACTION.